
## BUILDING EXPANSION PROJ SEEKINS PRECISION

2019

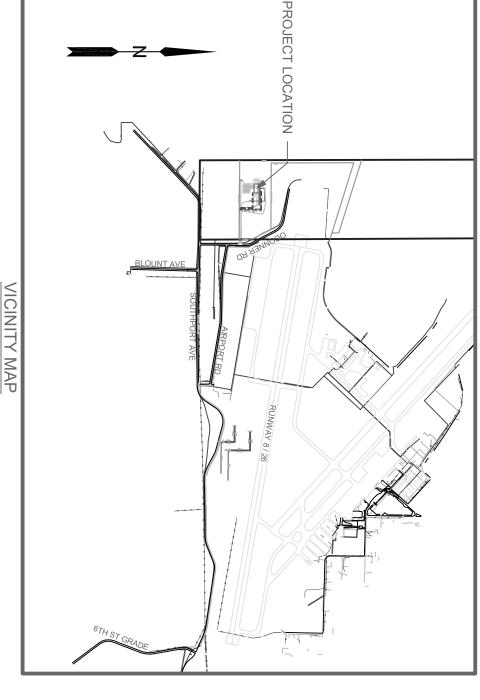

OWNER INFORMATION:
SEEKINS PRECISION
159 AMERICAN WAY
LEWISTON, ID 83501
208-743-3400

ENGINEER:
WARREN WATTS, P.E.
CLARKSTON, WA

509-780-9725

CITY OF LEWISTON:
PAT SEVERANCE, P.E.
215 D STREET
LEWISTON, ID 83501
208-563-6809

- NOTES:

  1. ALL WORK SHALL BE DONE IN ACCORDANCE WITH IDAHO STANDARDS FOR PUBLIC WORKS (ISPWC) SPECIFICATIONS ALL WATER SHALL BE INSTALLED PER ISPWC SECTION 401
- ALL SEWER SHALL BE INSTALLED PER ISPWC SECTION 500

	SHEET INDEX
ΞT#	SHEET DESCRIPTION
0	COVER
	CITY INSPECTION CHECKLIST
0	EXISTING SITE CONDITIONS
0	PROPOSED SITE PLAN
0	PROPOSED SANITARY SEWER PROFILE
0	PROPOSED WATER PROFILE
0	PROPERTY / EASEMENT LAYOUT
0	DETAILS
	DETAILS

SCALE: N.T.S.

		X	•	6			SAN		-		PROPOSED	
		×	ď	0	WTR	-SD	SAN —	YTU	,,,,,,,,,,,,,,,,,,,,,,,,,,,,,,,,,,,,,,,		EXISTING	LEGEND
0	DRY UTILITY BOX	GATE VALVE	FIRE HYDRANT	MANHOLE	WATERLINE	STORM SEWER	SANITARY SEWER	DRY UTILITY TRENCH	BUILDING	CENTERLINE		

			NCH		
CO.O	SCALE	DATE 02/12/19	APPROVED BY W. WATTS	DRAWN BY B. WALDEMARSON	18056

## **SEEKINS PRECISION BUILDING EXPANSION PROJECT**

**COVER SHEET** 

#	DATE	REVISIONS